



1 FLOOR PLAN
SCALE 1/8" = 1'-0"

MATERIAL LEGEND

A	ALUMINUM STOREFRONT W/ LOW-E INSULATED GLASS, WITH DARK BRONZE ANODIZED ALUMINUM STOREFRONT.
B	EXTERIOR CEMENT PLASTER SYSTEM
C	EIFS SINGLE COAT SYSTEM
D	CEMENT FIBER SIDING, PAINTED
E	METAL WALL PANEL, PAINTED
F	SMOOTH FACED CMU, PAINTED
G	BASALITE - STANDARD COLOR "113 - PRECISION"
H	SPLIT FACE CMU, PAINTED
I	BASALITE - STANDARD COLOR "128 - SPLIT FACE" RIVER STONE
J	METAL ROOFING
K	METAL - PARAPET CAP/PAINTEED STEEL/GATES/DOORS
L	ADDRESS NUMBER
M	SIGN BY OTHERS
N	GUARDRAIL
P	ROOF ACCESS LADDER
Q	WALL LIGHT FIXTURE
1	SHERWIN WILLIAMS - SW # 6107 "NOMADIC DESERT"
2	SHERWIN WILLIAMS - SW # 6147 "PANDA WHITE"
3	SHERWIN WILLIAMS - SW # 6053 "REDDENED EARTH"
4	SHERWIN WILLIAMS - SW # 6278 "CLOAK GRAY"

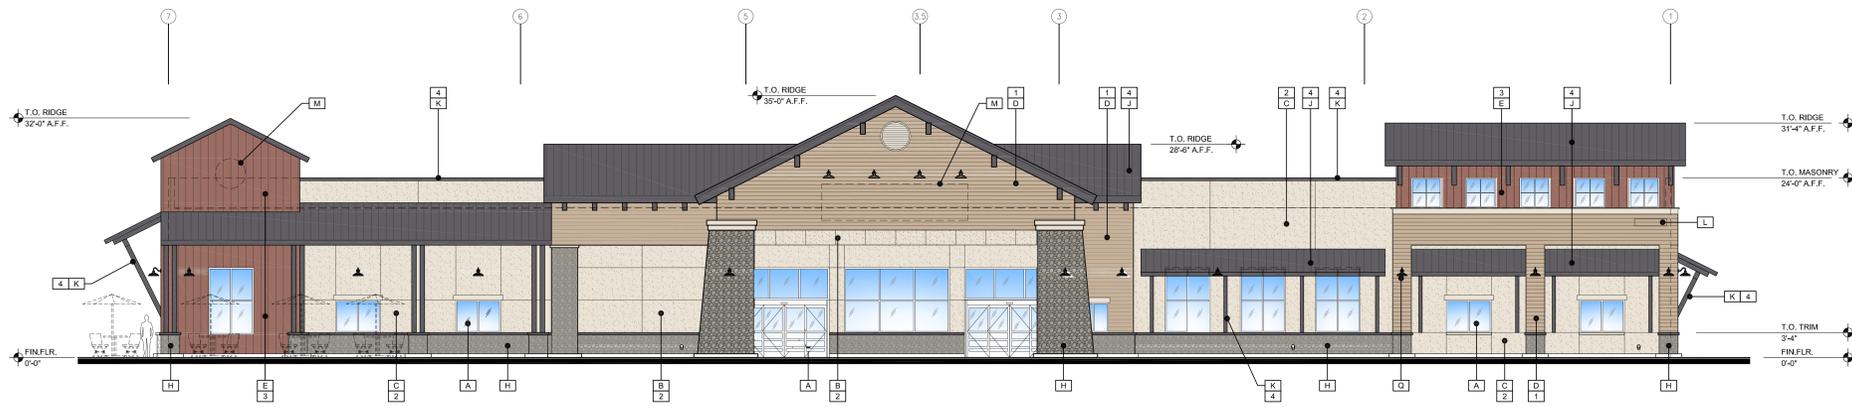


1 WEST ELEVATION
SCALE 1/8" = 1'-0"

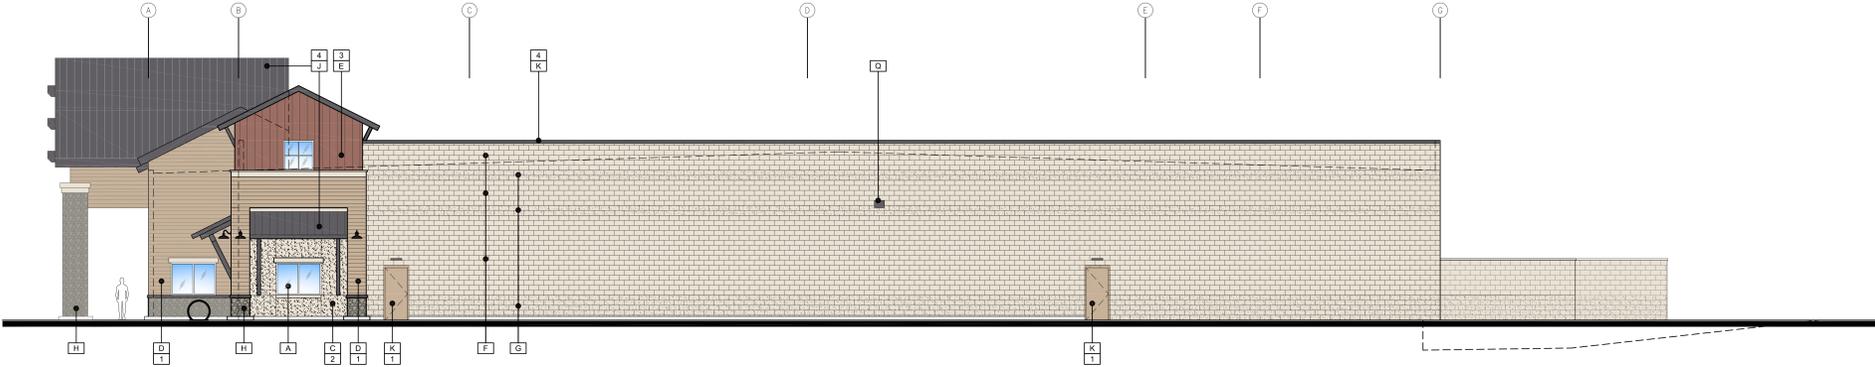


2 SOUTH ELEVATION
SCALE 1/8" = 1'-0"



3 EAST ELEVATION
SCALE 1/8" = 1'-0"

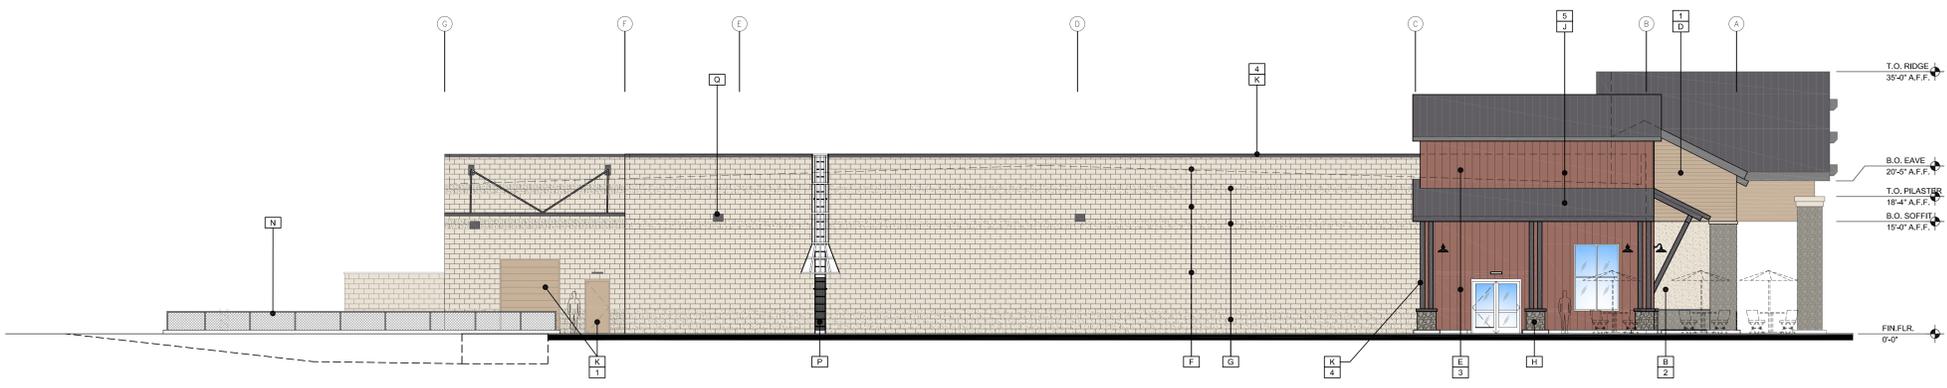

4 NORTH ELEVATION
SCALE 1/8" = 1'-0"

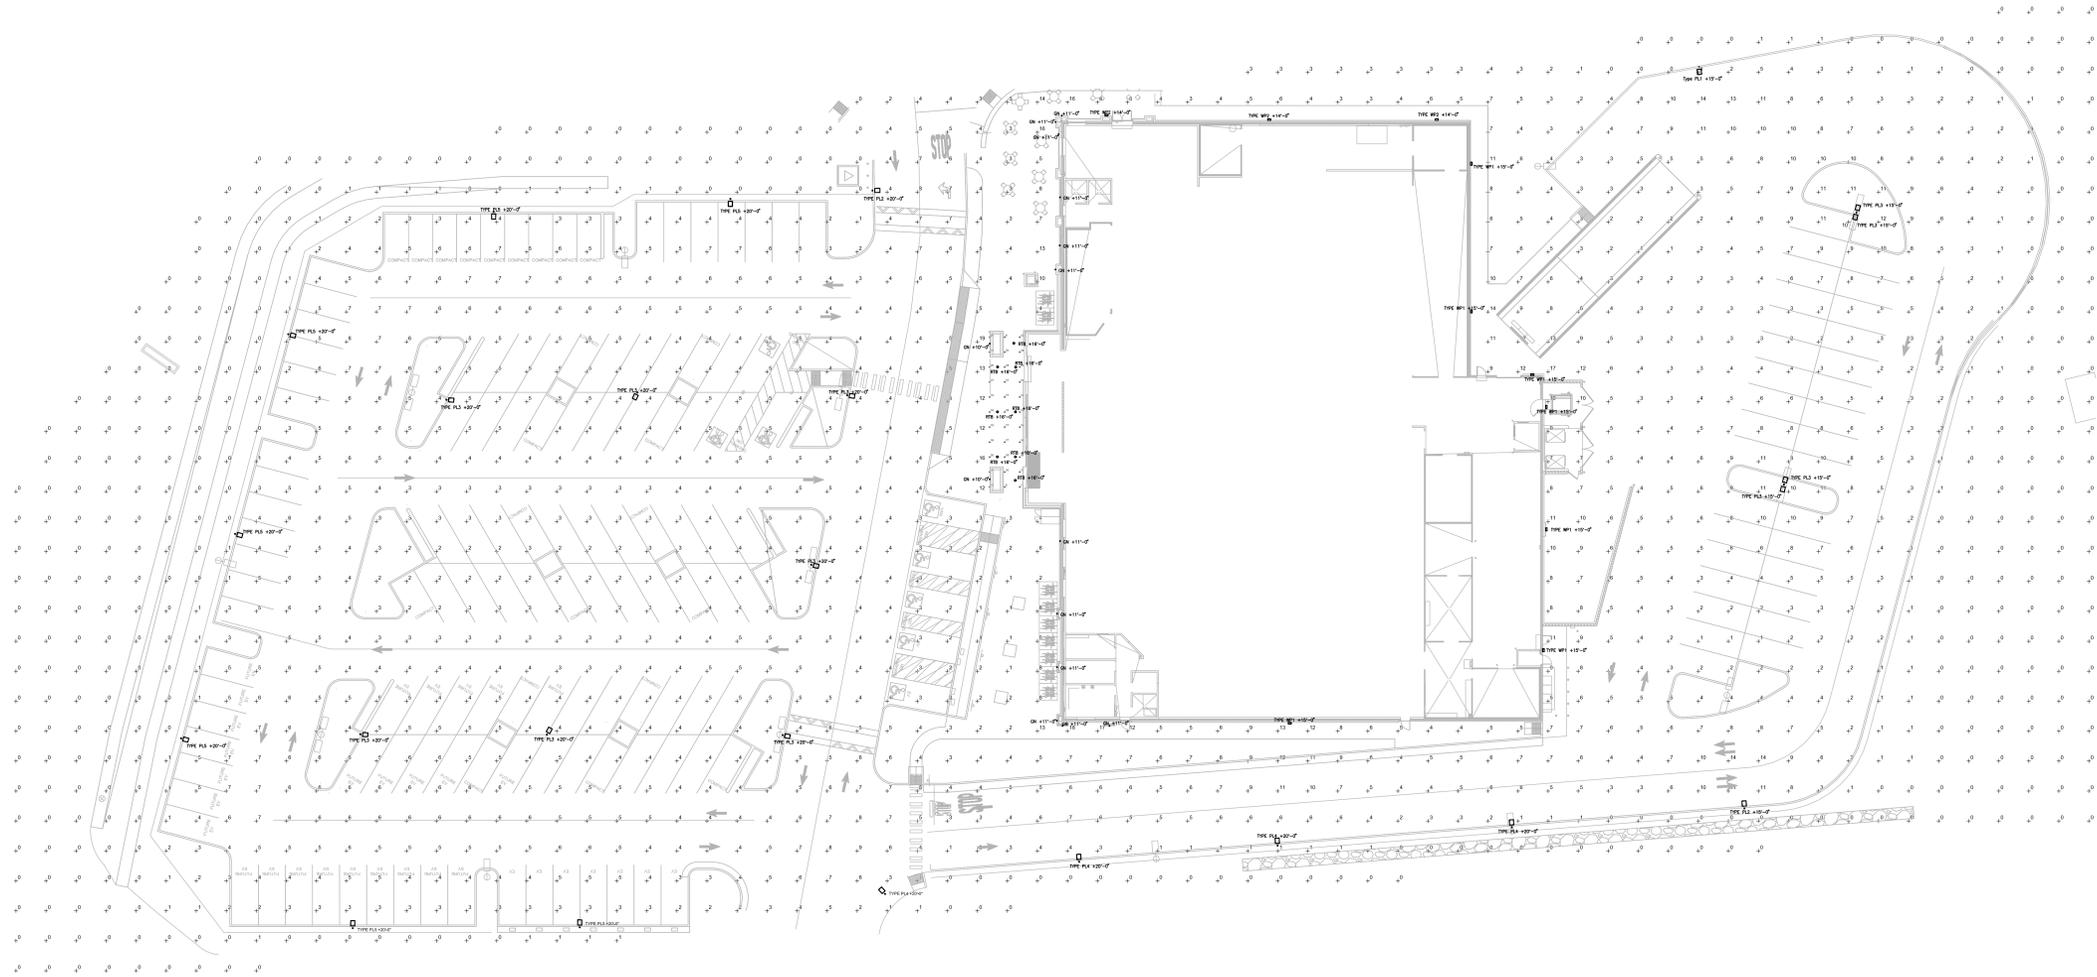

Schedule											
Symbol	Label	Image	Quantity	Manufacturer	Catalog Number	Description	Number Lamps	Lumens Per Lamp	Light Loss Factor	Wattage	Plot
	Type PL1		3	Litonia Lighting	DSX2 LED P4 40K 80CRI BLC3	D-Series Size 2 Area Luminaire P4 Performance Package 4000K CCT 80 CRI Type 3 Extreme Backlight Control	1	23286	0.95	272.65	
	TYPE PL2		3	Litonia Lighting	DSX2 LED P4 40K 80CRI BLC1	D-Series Size 2 Area Luminaire P4 Performance Package 4000K CCT 80 CRI Type 4 Extreme Backlight Control	1	24153	0.95	272.65	
	TYPE PL3		8	Litonia Lighting	DSX1 LED P2 40K 80CRI TSM	D-Series Size 3 Area Luminaire P2 Performance Package 4000K CCT 80 CRI Type 5 Medium	1	23880	0.95	179.32	
	TYPE PL4		4	Litonia Lighting	DSX2 LED P2 40K 80CRI BLC3	D-Series Size 2 Area Luminaire P2 Performance Package 4000K CCT 80 CRI Type 3 Extreme Backlight Control	1	16634	0.95	179.22	
	TYPE PL5		7	Litonia Lighting	DSX2 LED P1 40K 80CRI BLC2	D-Series Size 2 Area Luminaire P1 Performance Package 4000K CCT 80 CRI Type 3 Extreme Backlight Control	1	13061	0.95	134.5	
	TYPE WP1		7	Litonia Lighting	WDG3 LED P4 70CRI R4 40K	WDG3 LED WITH P4 - PERFORMANCE PACKAGE, 4000K, 70CRI, TYPE 4 OPTIC	1	12537	0.95	87.8934	
	TYPE WP2		3	Litonia Lighting	WDG3 LED P1 70CRI R3 40K	WDG3 LED WITH P1 - PERFORMANCE PACKAGE, 4000K, 70CRI, TYPE 3 OPTIC	1	7523	0.95	51.1717	
	RT8		8	LEOVANCE	LED/RT8/3000/140 (Sample 1) in a Cooper CB042 recessed fixture		1	3398	0.95	34.9	
	GN		14	Sprizer	BL-GSRNVD-42W-01W3		1	3822	0.95	40.014	

