 

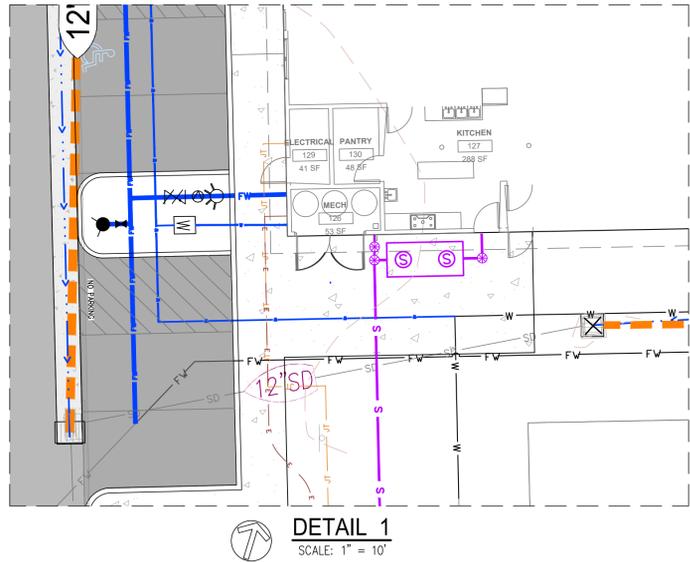


LEGEND	
EXISTING	PROPOSED
	DRAINAGE SWALE
	CONCRETE PAVEMENT
	TRENCH / DRAIN
	ASPHALT PAVEMENT
	DRAIN INLET
	HDPE STORM DRAIN PIPE
	4" PERFORATED PIPE
	SEWER LINE
	SANITARY SEWER CLEANOUT
	GAS LINE
	WATER LINE
	FIRE LINE
	BACKFLOW PREVENTER
	FIRE DEPARTMENT CONNECTION
	POST INDICATOR VALVE
	FIRE HYDRANT
	1500 GAL. GREASE INTERCEPTOR
	WATER METER
	UNDERGROUND ELECTRICAL LINE
	OVERHEAD ELECTRICAL LINE
	TRANSFORMER
	COMMUNICATION LINE
	JOINT UTILITY

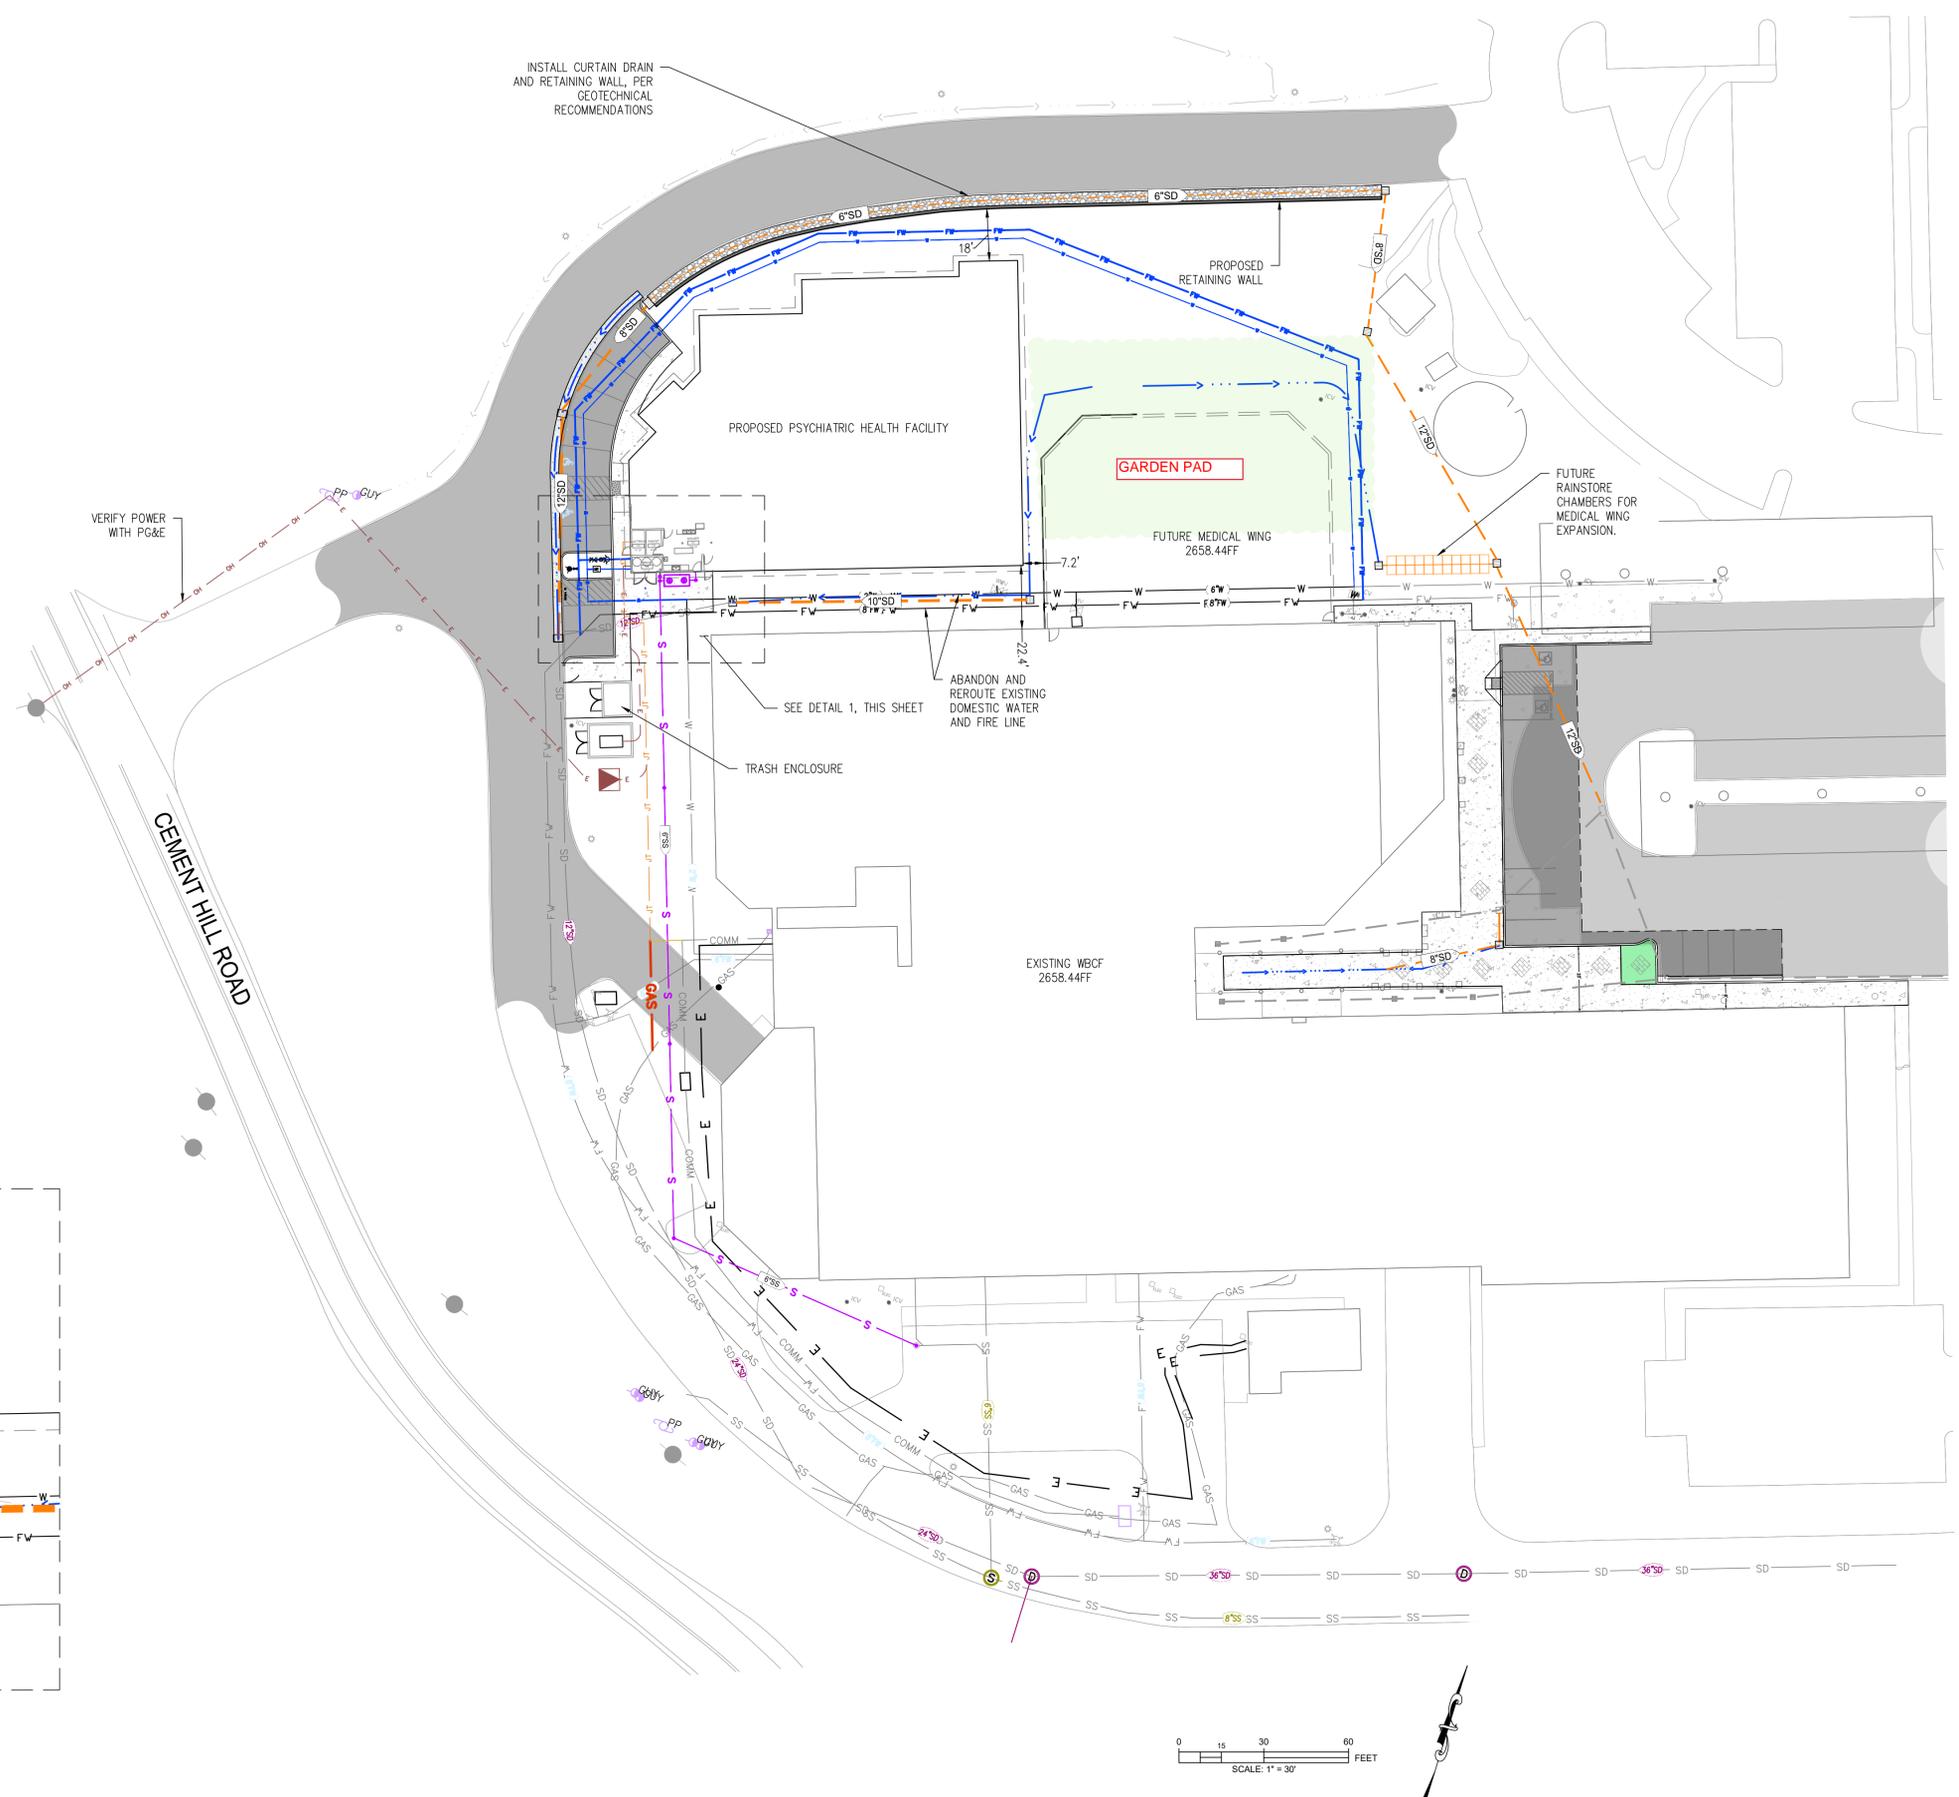

REV.	DESCRIPTION	DATE

PSYCHIATRIC HEALTH FACILITY  
925 MAIDU AVE  
NEVADA CITY, CA 95959  
PRELIMINARY UTILITY PLAN

PROJECT NO: 24-1015  
DATE: JUNE, 2025  
SHEET NUMBER:  
**C2.0**